

## COMMUNICATIONS EQUIPMENT ROOM CER.120

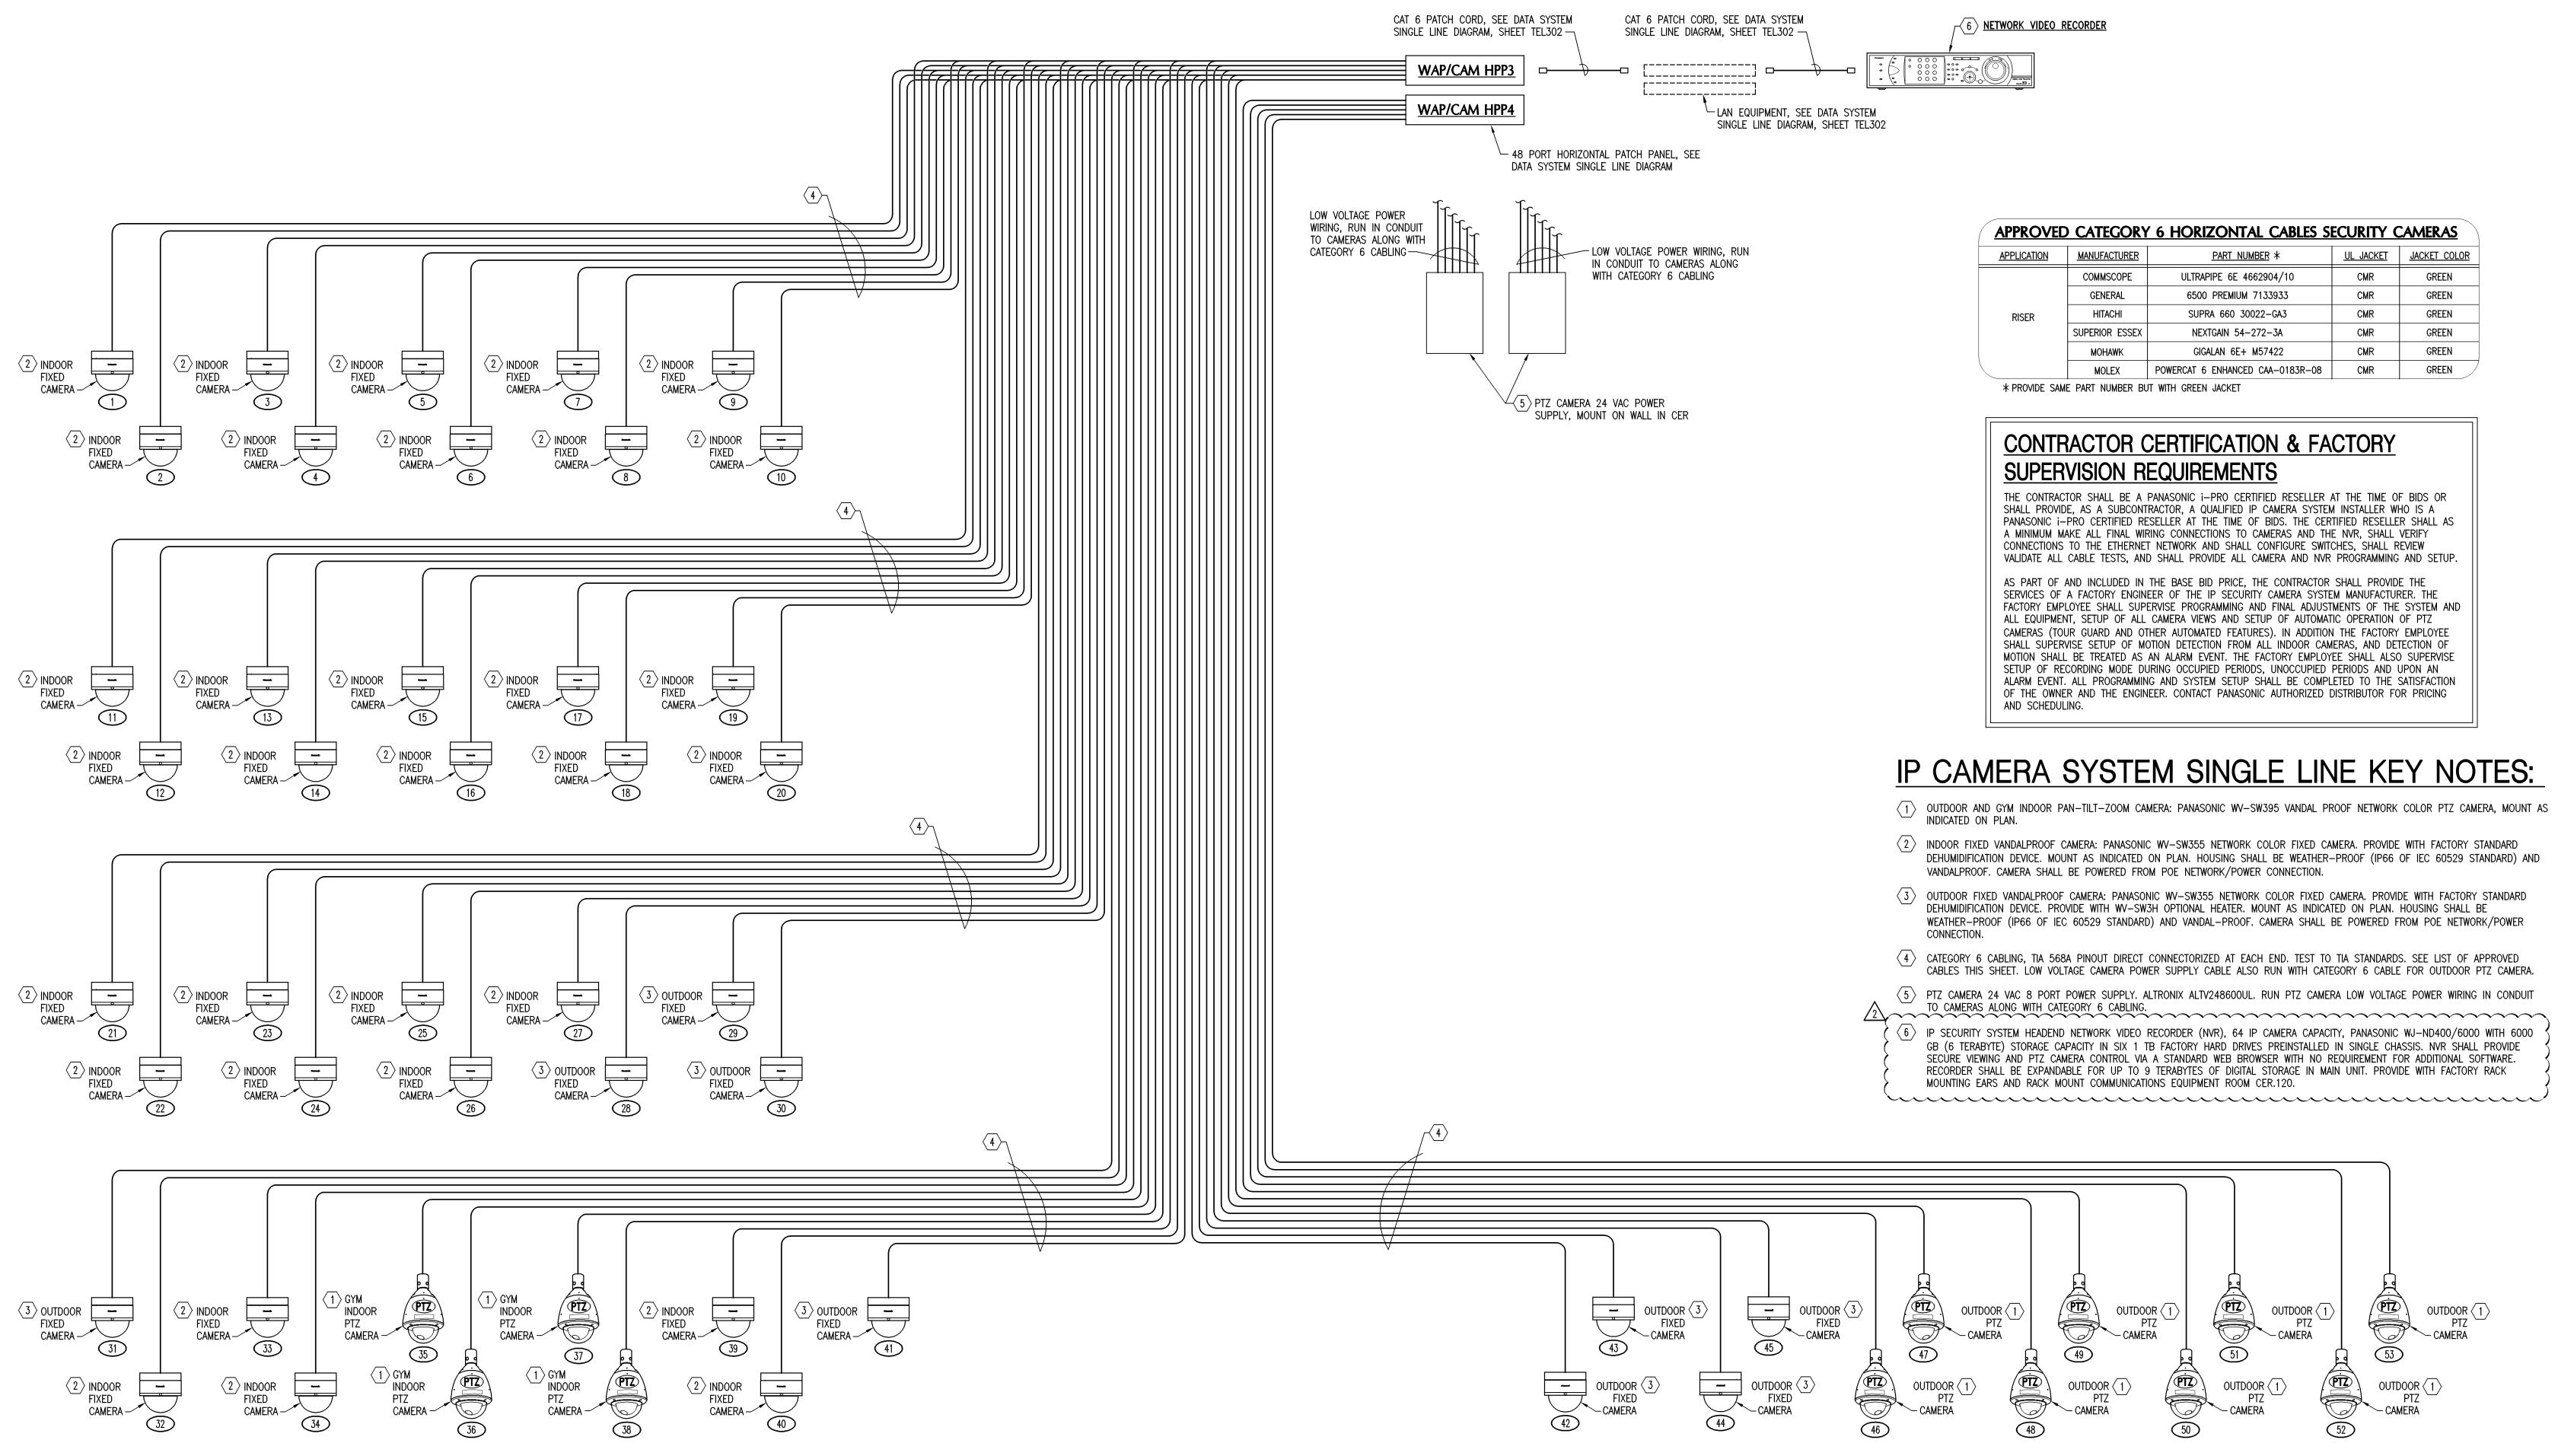

IP SECURITY CAMERA SYSTEM SINGLE LINE DIAGRAM
NOT TO SCALE

NOTE: RUN ALL CABLES CONTINUOUS BETWEEN TERMINATION POINTS INDICATED WITH NO INTERMEDIATE SLICES OR TERMINATIONS.

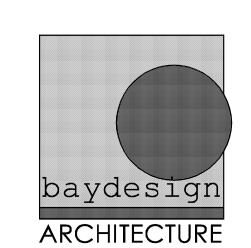



architecture + sustainability
720 bayfront parkway
suite 200
pensacola, fl 32502
t: 850.432.0706
f: 850.433.0508

baydesign.com	
EAL	

| Samuel L. Gulley, PE #5000

bay design associates architects, p

associates architects, pl florida certificate of authorization AA0003597


Shoreline Drive
Gulf Breeze, FI 32561
SHEET TITLE:

IP SECURITY CAMERA SYSTEM SINGLE LINE DIAGRAM

PROJECT NO:
FILE NO:
DATE: 06.01.2011
REVISION:
2-06.20.2011

SHEET

TEL303

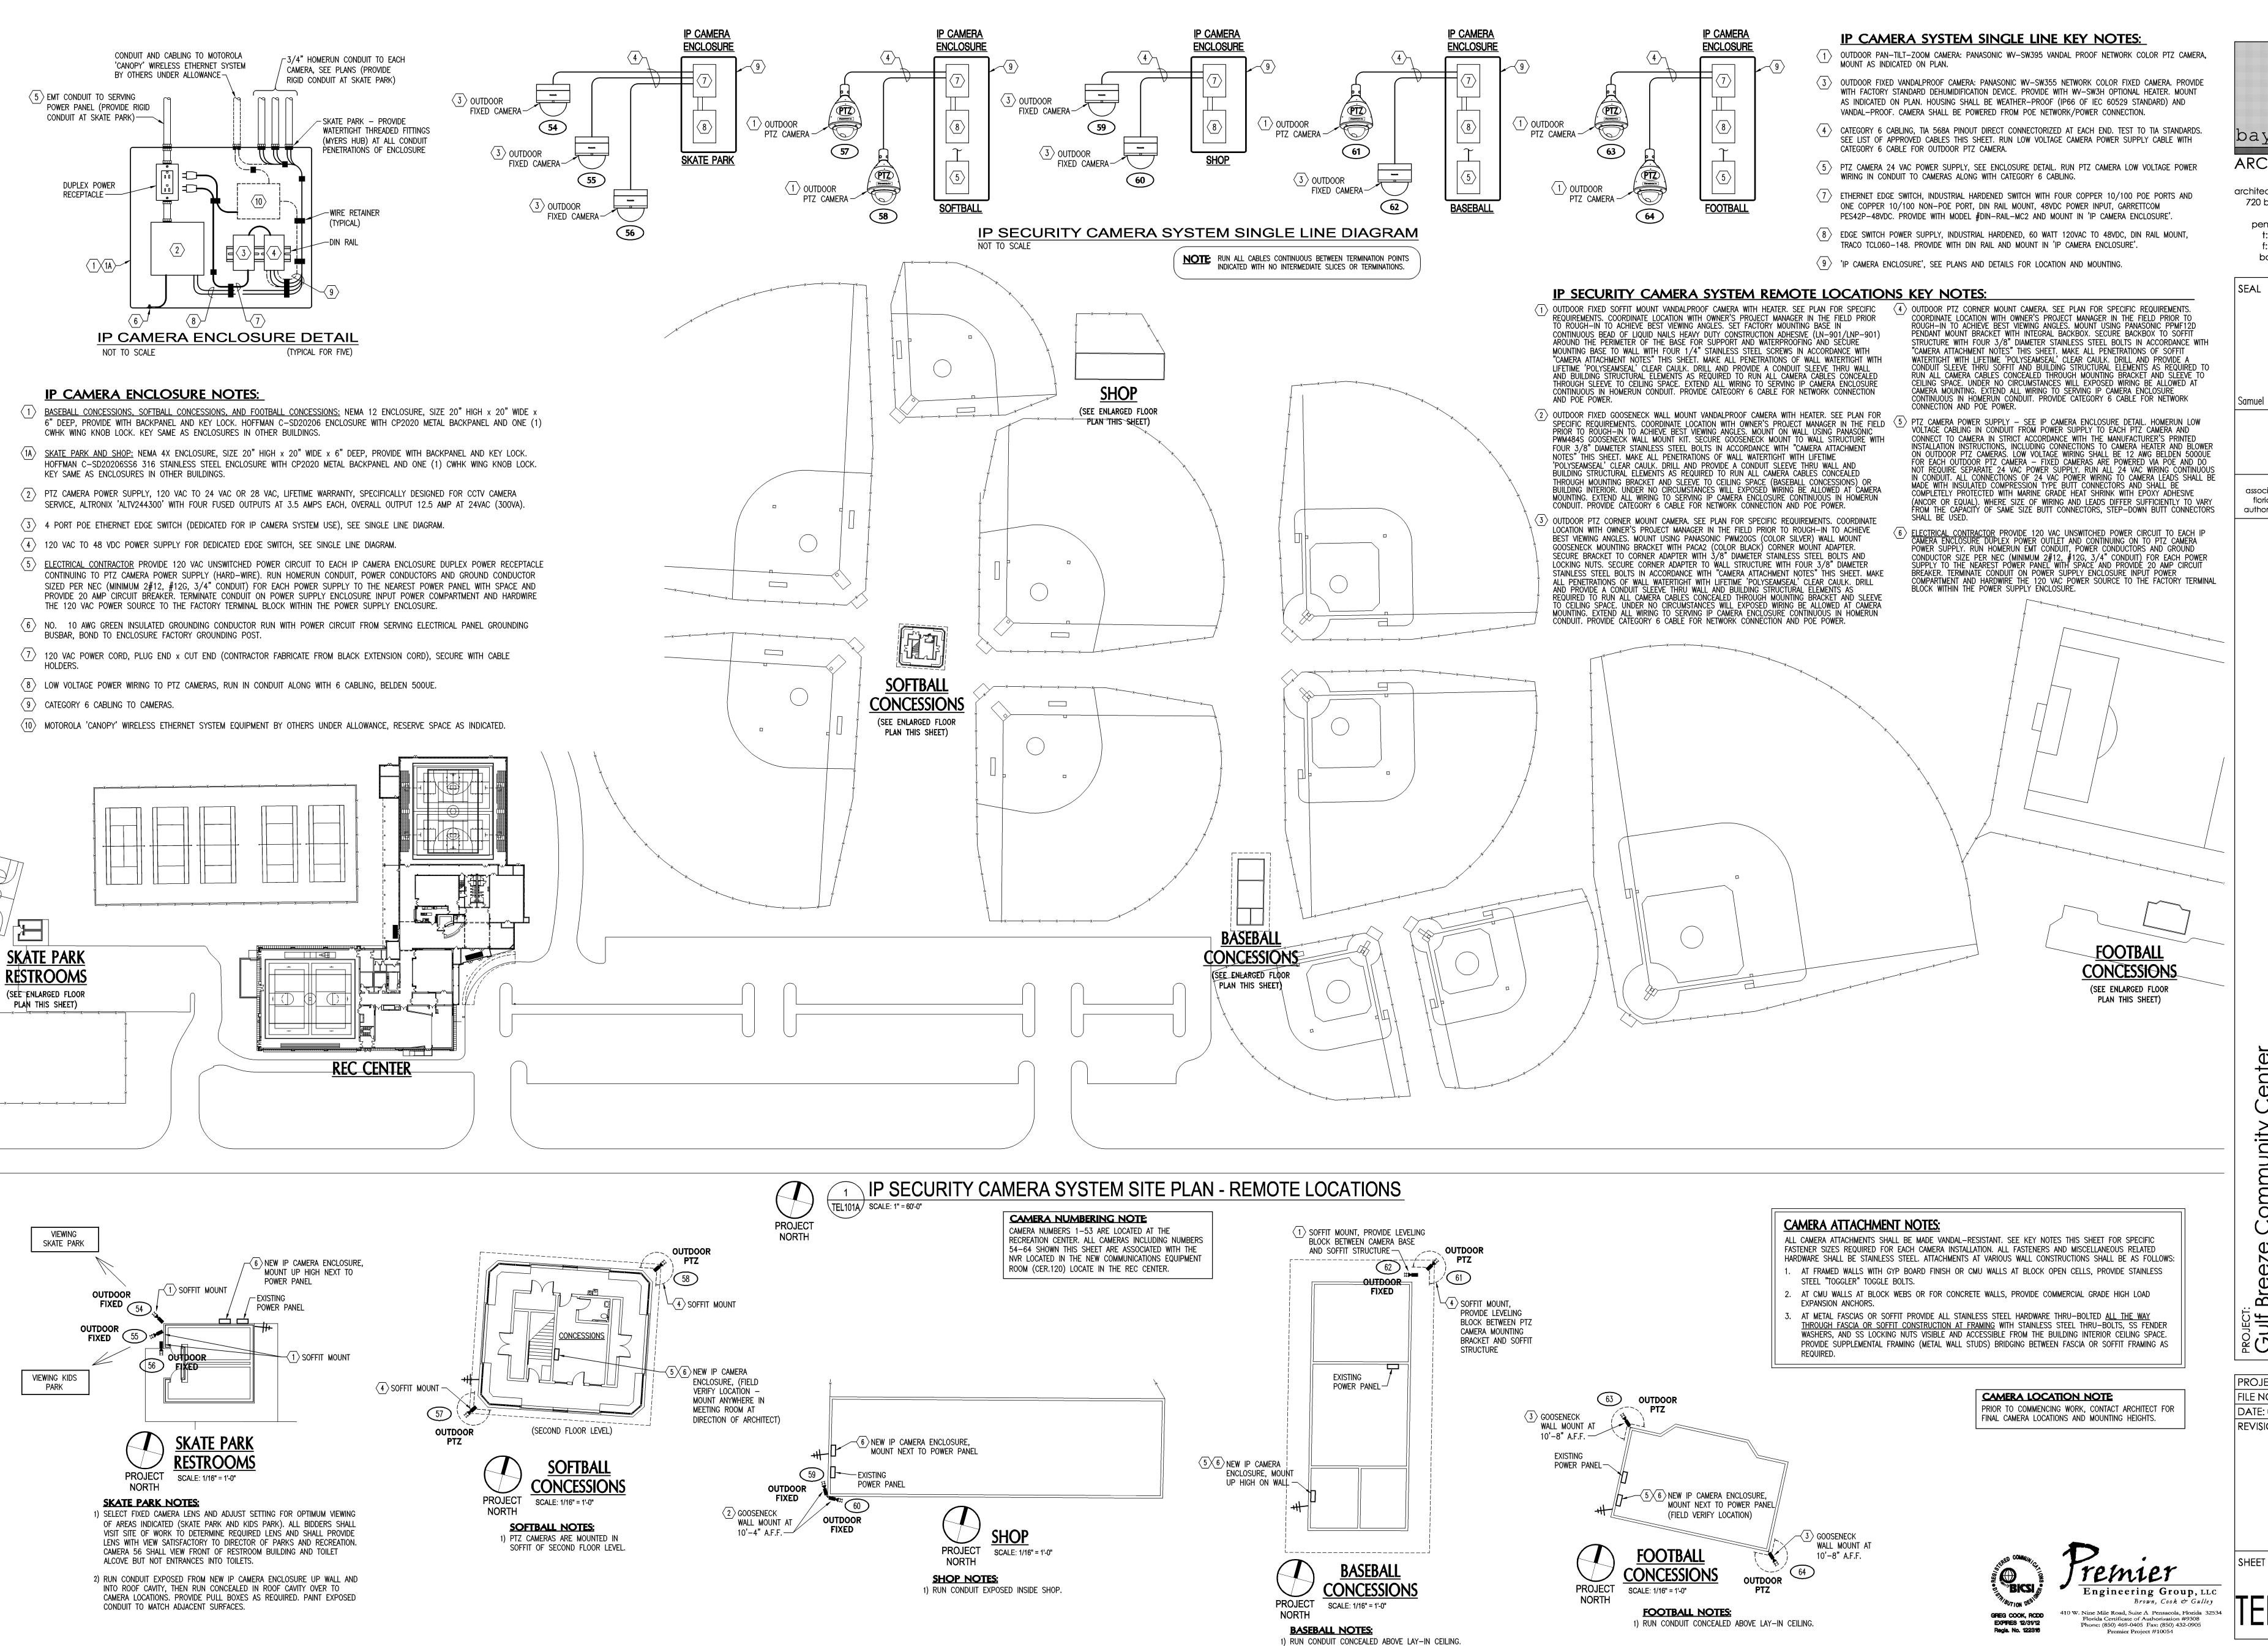

baydesign

**ARCHITECTURE** 

architecture + sustainability 720 bayfront parkway suite 200 pensacola, fl 32502 t: 850.432.0706 f: 850.433.0508 baydesign.com

Samuel L. Gulley, PE #5000

bay design associates architects, pl florida certificate of authorization AA0003597

SITE

SYSTEM

EET TITLE:
SECURITY

PROJECT NO:

FILE NO: XXXXX DATE: 06.20.2011 REVISION: