
## NEW WORK KEY NOTES

- 1 PROVIDE STAINLESS STEEL COVER OVER REFRIGERANT PIPING PER DETAIL.
- 2 PROVIDE SOFFIT GRILLE WITH FACTORY BRONZE KYNAR FINISH.
- 3 PROVIDE NEW DDC PANEL IN MECHANICAL ROOM. PANEL SHALL SERVE ALL NEW EQUIPMENT IN THIS WING.
- 4 COORDINATE DUCTWORK IN CORRIDOR WITH LIGHTS AND CABLE TRAYS.
- 5 TRANSITION DUCTWORK AS REQUIRED FOR CONNECTION TO UNIT. INSTALL DUCT-MOUNTED SMOKE DETECTOR IN THE RETURN AIR DUCT UPSTREAM OF O/A DUCT CONNECTION.
- 6 OUTDOOR UNIT AIRFLOW SHALL BE AWAY FROM BUILDING.
- ROUTE CONDENSATE DRAIN AND REFRIGERANT PIPE IN INTERIOR WALL AND ABOVE CEILING TO EXTERIOR WALL. ROUTE PIPE TO GRADE IN EXTERIOR WALL. ROUTE CONDENSATE DRAIN PIPE TO NEAREST ROOF DRAIN LEADER. VERIFY LOCATION OF EXISTING ROOF DRAIN LEADER AND COORDINATE NEW WITH ARCHITECTURAL. ROUTE REFRIGERANT PIPE TO CONDENSING UNIT.
- (8) PROVIDE DUCT TRANSITION AS REQUIRED FOR CONNECTION TO EQUIPMENT.
- (9) REINFORCED MASONRY OR PRECAST LINTELS SHALL BE PROVIDED ABOVE ALL MASONRY PENETRATION GREATER THAN 12" WIDE.
- 10 LOCATE EXHAUST GRILLE 15'-0" (MINIMUM) FROM OUTSIDE AIR INTAKE.
- ⟨↑⟩ WALL-MOUNTED INDOOR MINI-SPLIT UNIT. MOUNT MINI-SPLIT ABOVE DOOR. COORDINATE EXACT LOCATION WITH COM. EQUIPMENT.
- DDC SPACE TEMPERATURE SENSOR. MOUNT AT 60" A.F.F.

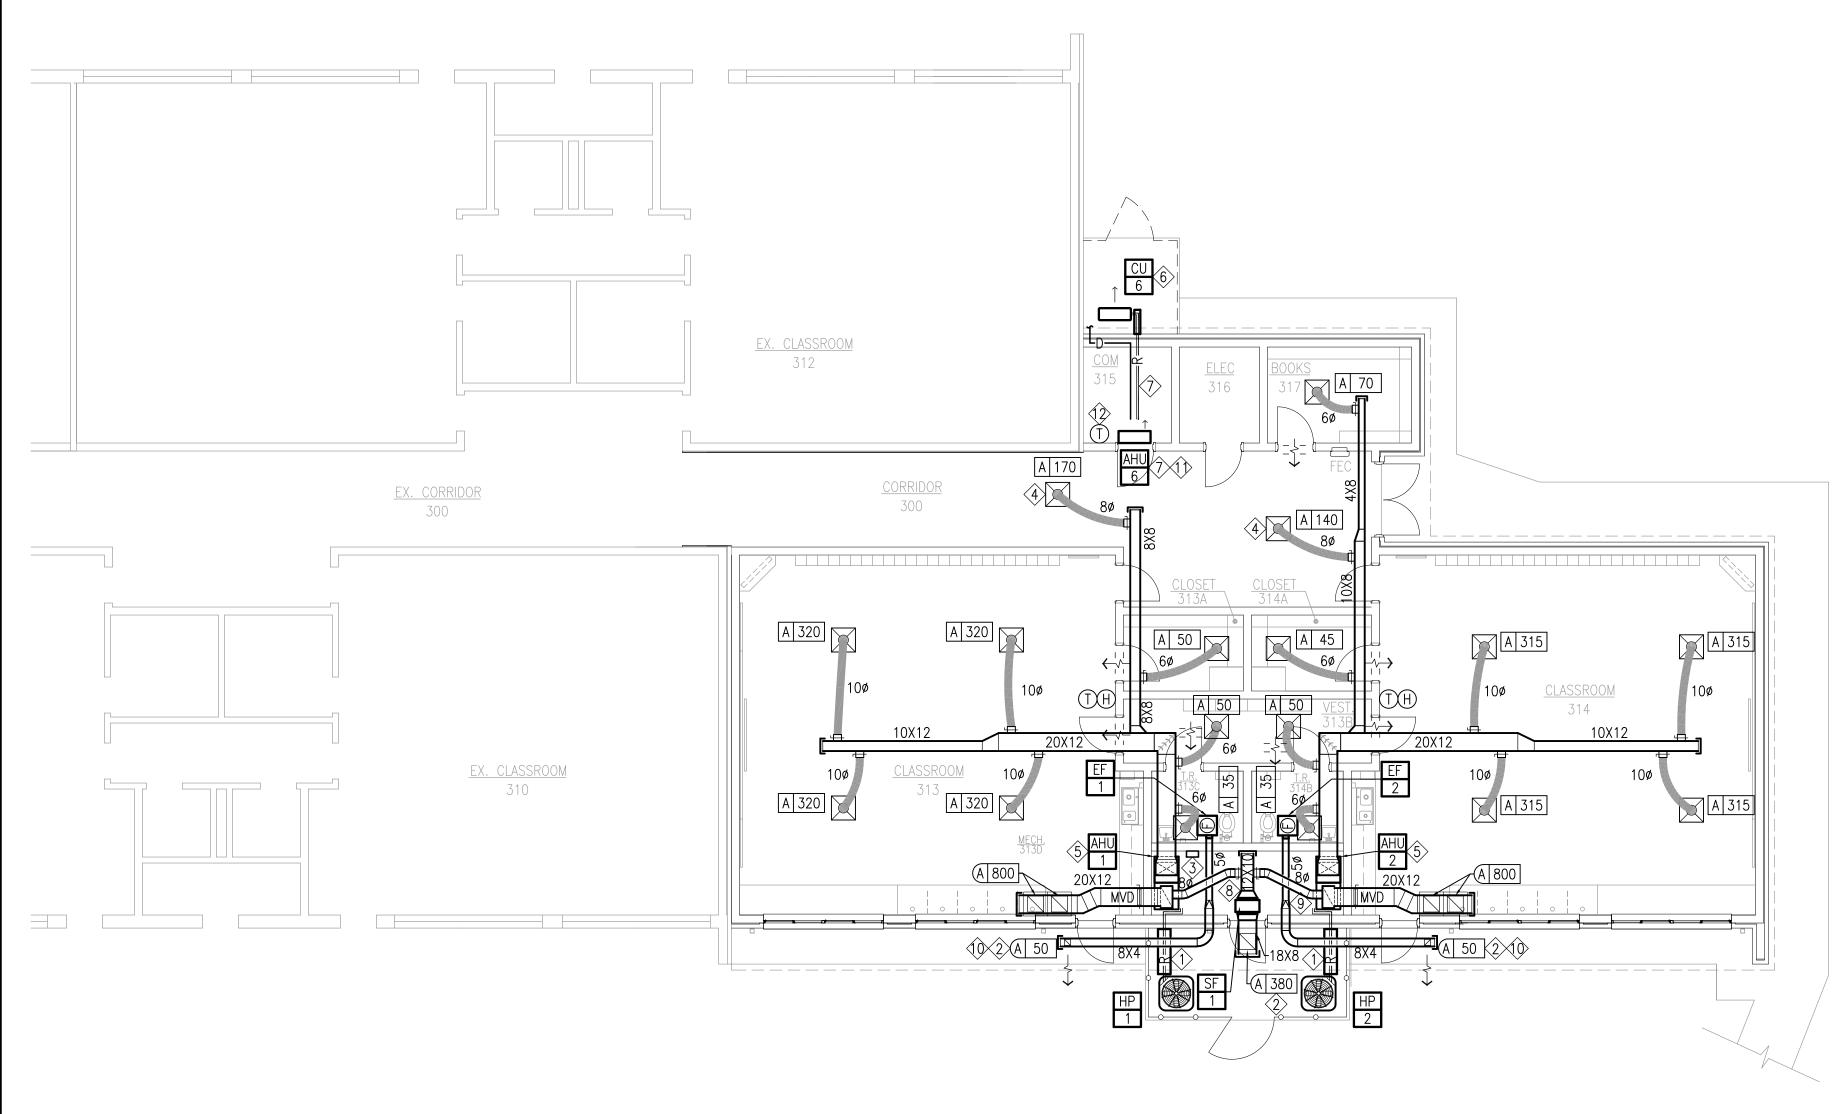





PINDER-MARTIN ASSOCIATES, INC 1001 N. 12th AVENUE PENSACOLA, FL 32501 850-439-9110

AA26000896

PROJECT:

5 CLASSROOM ADDITION

LOCATION:
WEST NAVARRE INTERMEDIATE
SCHOOL

1970 COTTON BAY LANE NAVARRE, FL 32566

CONSULTANTS:


JEHLE-HALSTEAD INC.
49 EAST CHASE STREET
PENSACOLA, FL 32502

CRAFT & WEBSTER
STRUCTURAL ENGINEERING, INC.

STRUCTURAL ENGINEERING, IF 129 HIGHPOINT DRIVE GULF BREEZE, FL 32561

GULF BREEZE CONSULTING, INC.
139 EAST GOVERNMENT STREET
PENSACOLA, FL 32502

ADAMS CONSULTING ENGINEERING, INC. 3 WEST GARDEN STREET – SUITE 382 PENSACOLA, FL 32502

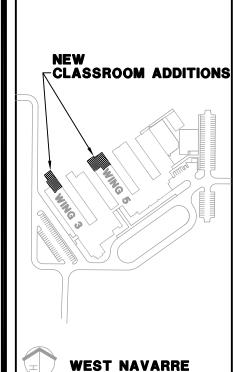

INTERMEDIATE

No. Revision/Issue Date

KENNETH L. GONZALEZ ENGINEER OF RECORD

DRAWN BY:
CHECKED BY:
PINDER-MARTIN ASSOCIATES, INC

REVIEW: 09-06-11
PERMITTING: 09-09-11
RELEASE FOR BIDDING: 09-19-11

NEW WORK FLOOR PLAN WING 3

M1 1

GULF BREEZE CONSULTING!

139 East Government
Pensacola \* FL \* 32502 \* 850.453.6630

Consulting
Engineers