


Zone #2

Hydraulic Area
.10 Densy@900 Sq.Ft.

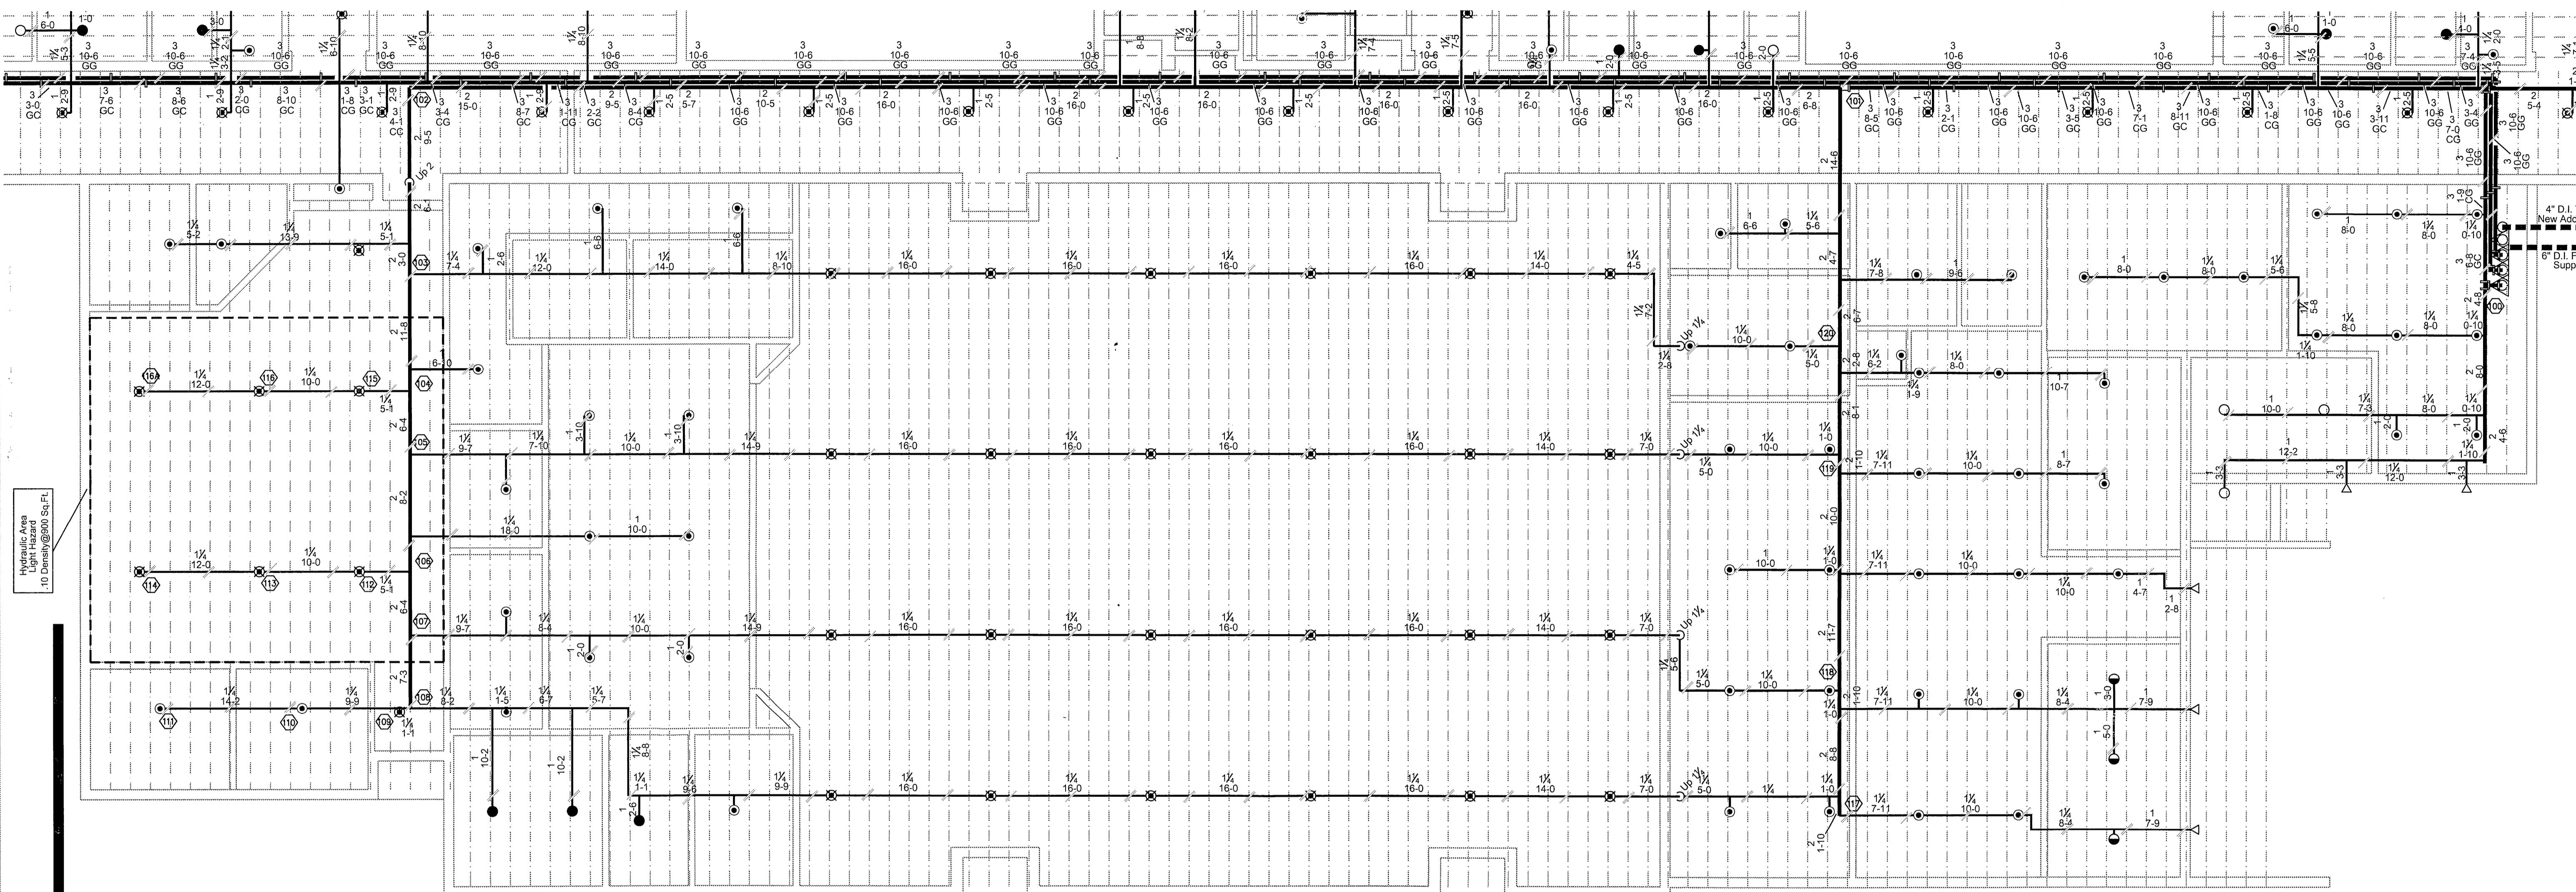

Kitchen/Cafeteria Wing #100 Piping Plan

Scale: 1/8"=1'-0"

KEY PLAN



0 8 16
SCALE IN FEET

GRAPHIC SCALE

SHEET TITLE:
Kitchen/Cafeteria
#100 Piping Plan

DRAWN BY: MAT
CHECKED BY: SJN
APPROVED BY:
PROJECT NO: 11-018
DATE: 2-24-11

SHEET
FP2

REVISIONS

P.O. Box 7646
Pensacola, FL 32534
(850) 206-5269
Fax (850) 958-0206



SEAL:

West Navarre
Intermediate
School

1970 Cotton Bay Lane
Navarre, Florida 32566